



LIGHTING FIXTURE SCHEDULE			
TYPE MARK	DESCRIPTION	COUNT	COMMENTS
F1	RECESSED or SURFACE MOUNT LIGHT	16	LED
F2	CEILING FAN	2	DIMMER, NO LIGHT KIT. PROVIDE BLOCKING FOR MIN. 100 LBS.
F3	WALL SCONCE	1	RATED FOR WET LOCATIONS
F4	WALL SCONCE	1	RATED FOR EXTERIOR LOCATIONS

ELECTRICAL LEGEND


	DUPLEX OUTLET		RECESSED DIRECTIONAL LIGHT
	DUPLEX OUTLET MOUNTED 42\"/>		RECESSED DOWNLIGHT / UPLIGHT
	GFI DUPLEX OUTLET		WALL MOUNTED LIGHT FIXTURE
	DUPLEX OUTLET W/ EXTERIOR BOX		CEILING MOUNTED LIGHT FIXTURE
	220V OUTLET		EXTERIOR 150 WATT FLOODLIGHT ON PHOTOCELL
	RECESSED FLOOR DUPLEX OUTLET		CEILING FAN [NO LIGHT KIT]
	LIGHT SWITCH		TELEPHONE / DATA
	DIMMER SWITCH		CABLE TV OUTLET 2-DUPLEX OUTLETS 1 CAT 6 DATA OUTLET
	3-WAY SWITCH		GARBAGE DISPOSAL
	LIGHT, VENT, HEATER		UNDER CABINET FIXTURE
	CEILING MOUNTED HARD WIRED COMBINATION SMOKE DETECTOR/CARBON MONOXIDE DETECTOR		FLUORESCENT STRIP

MECHANICAL LEGEND


	MECHANICAL SUPPLY AIR DIFFUSER
	MECHANICAL EXHAUST / BATHROOM VENT
	MECHANICAL RETURN AIR DIFFUSER
	ACCESS PANEL
	MECHANICAL SUPPLY AIR, SIDEWALL DIFFUSER
	MECHANICAL SIDEWALL RETURN
	THERMOSTAT
	(BASIS OF DESIGN IS 'NEST', INSTALL ALL COMPONENTS AS REQ'D BY MFR., INCLUDING DATA, POWER, ETC.)

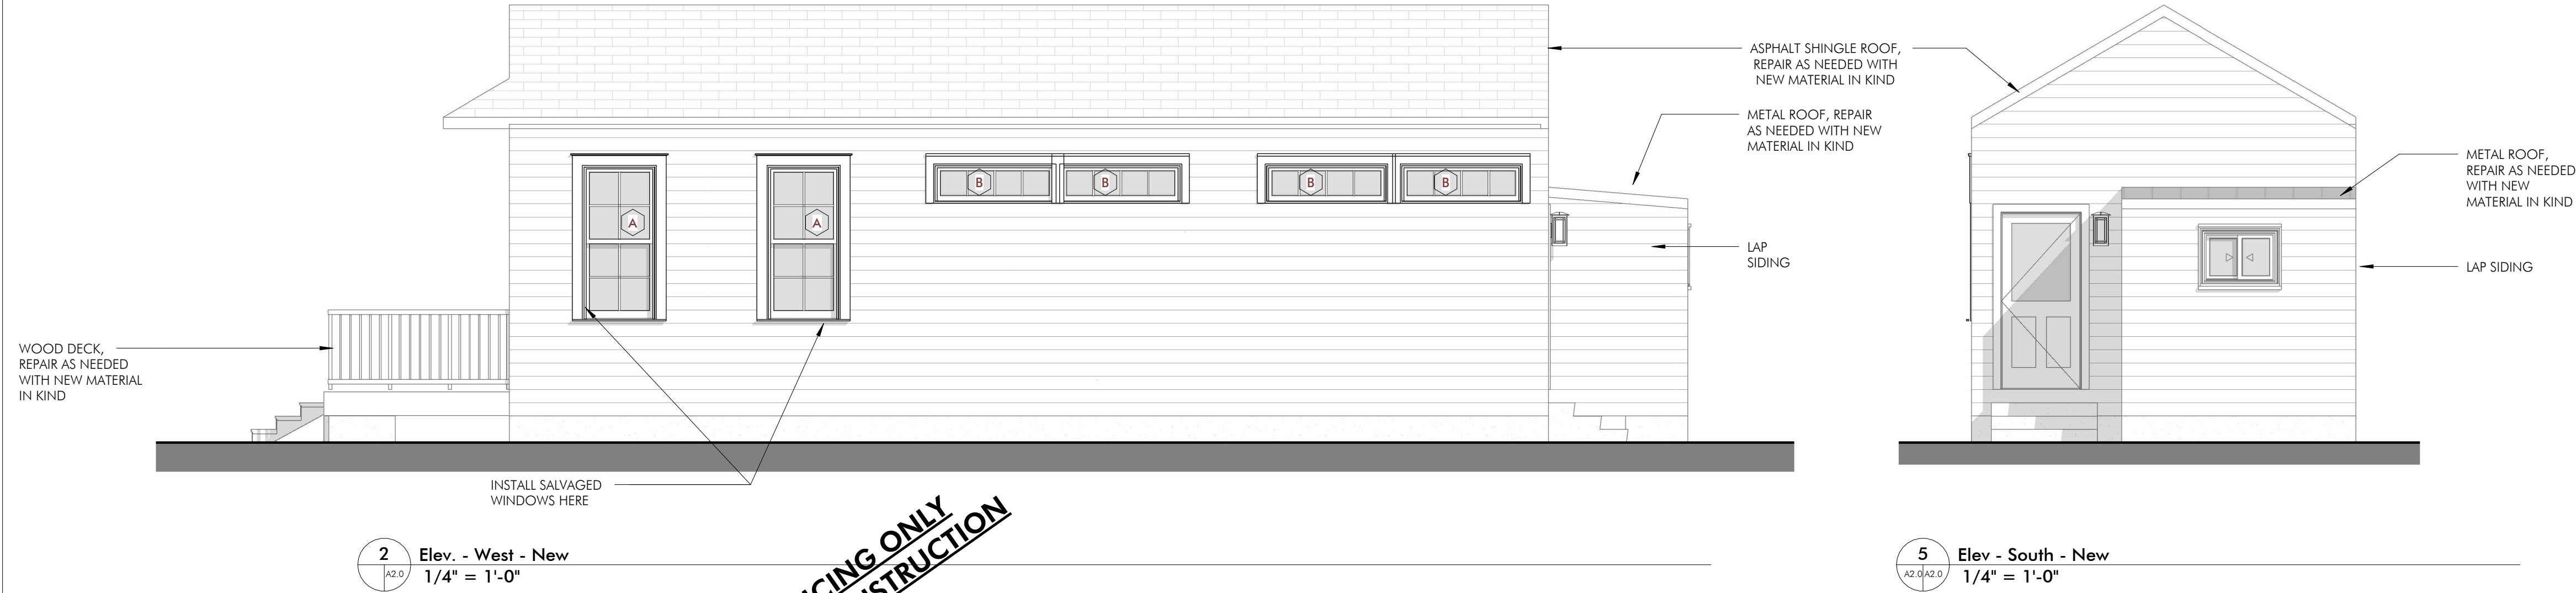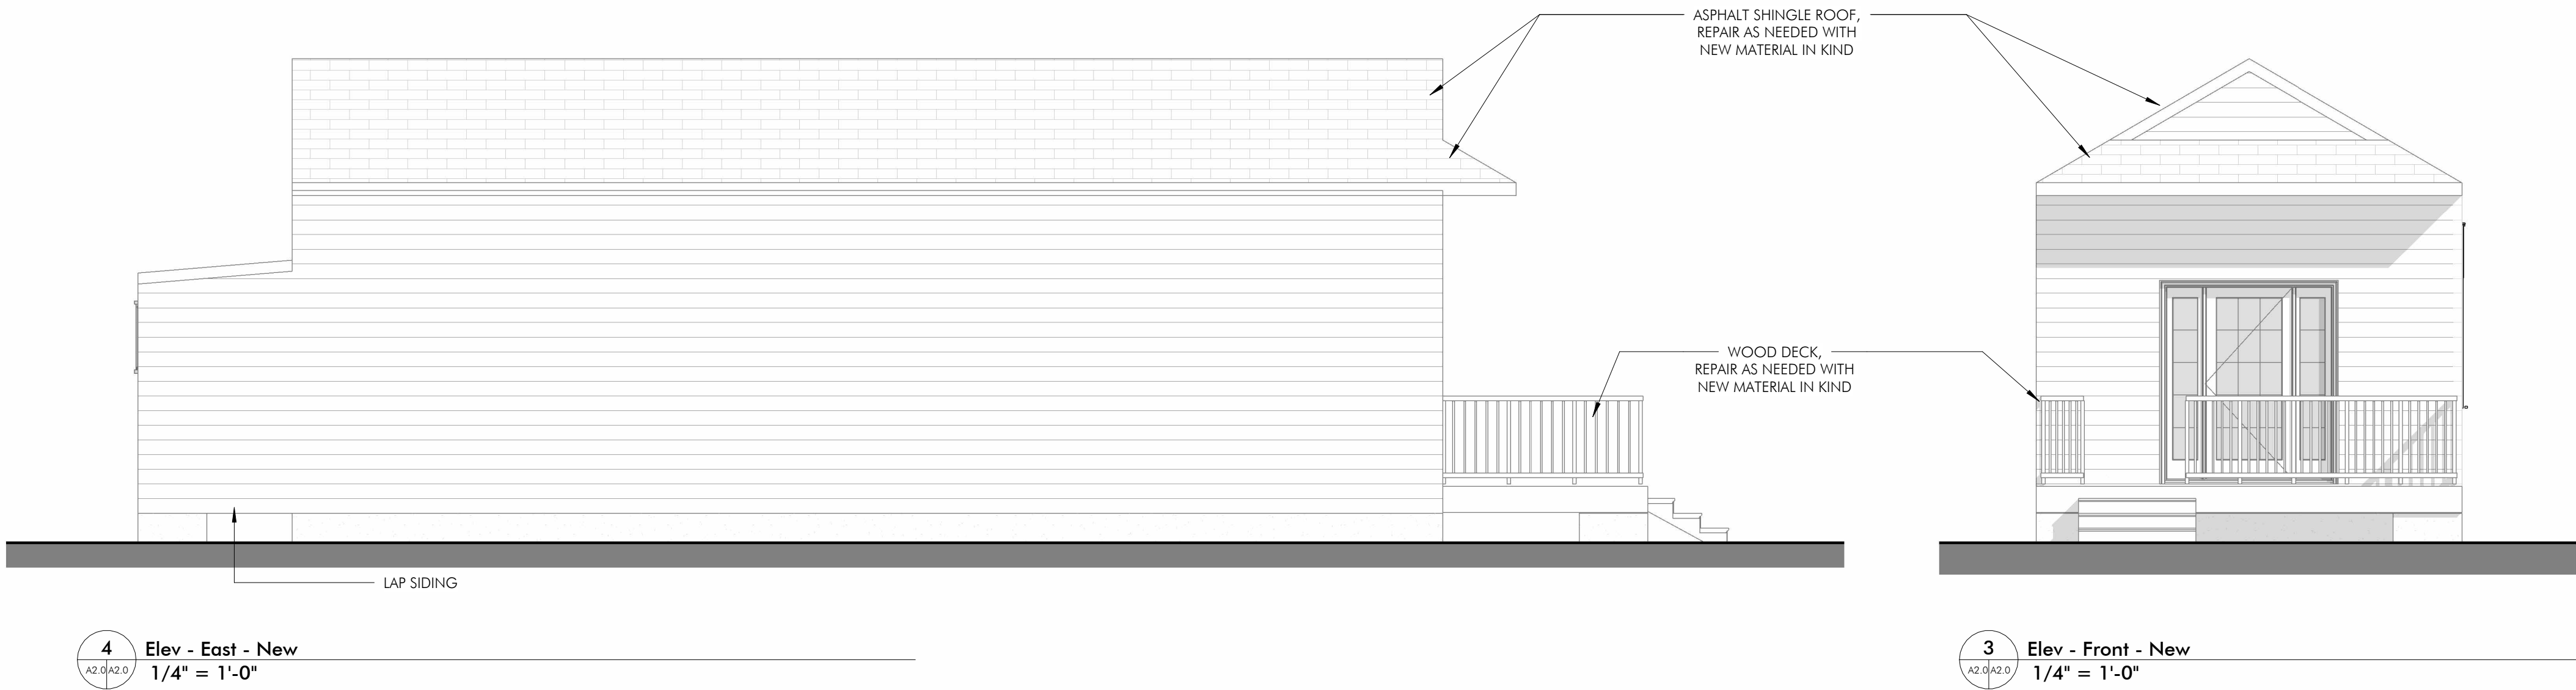

FOR PRICING ONLY
NOT FOR CONSTRUCTION

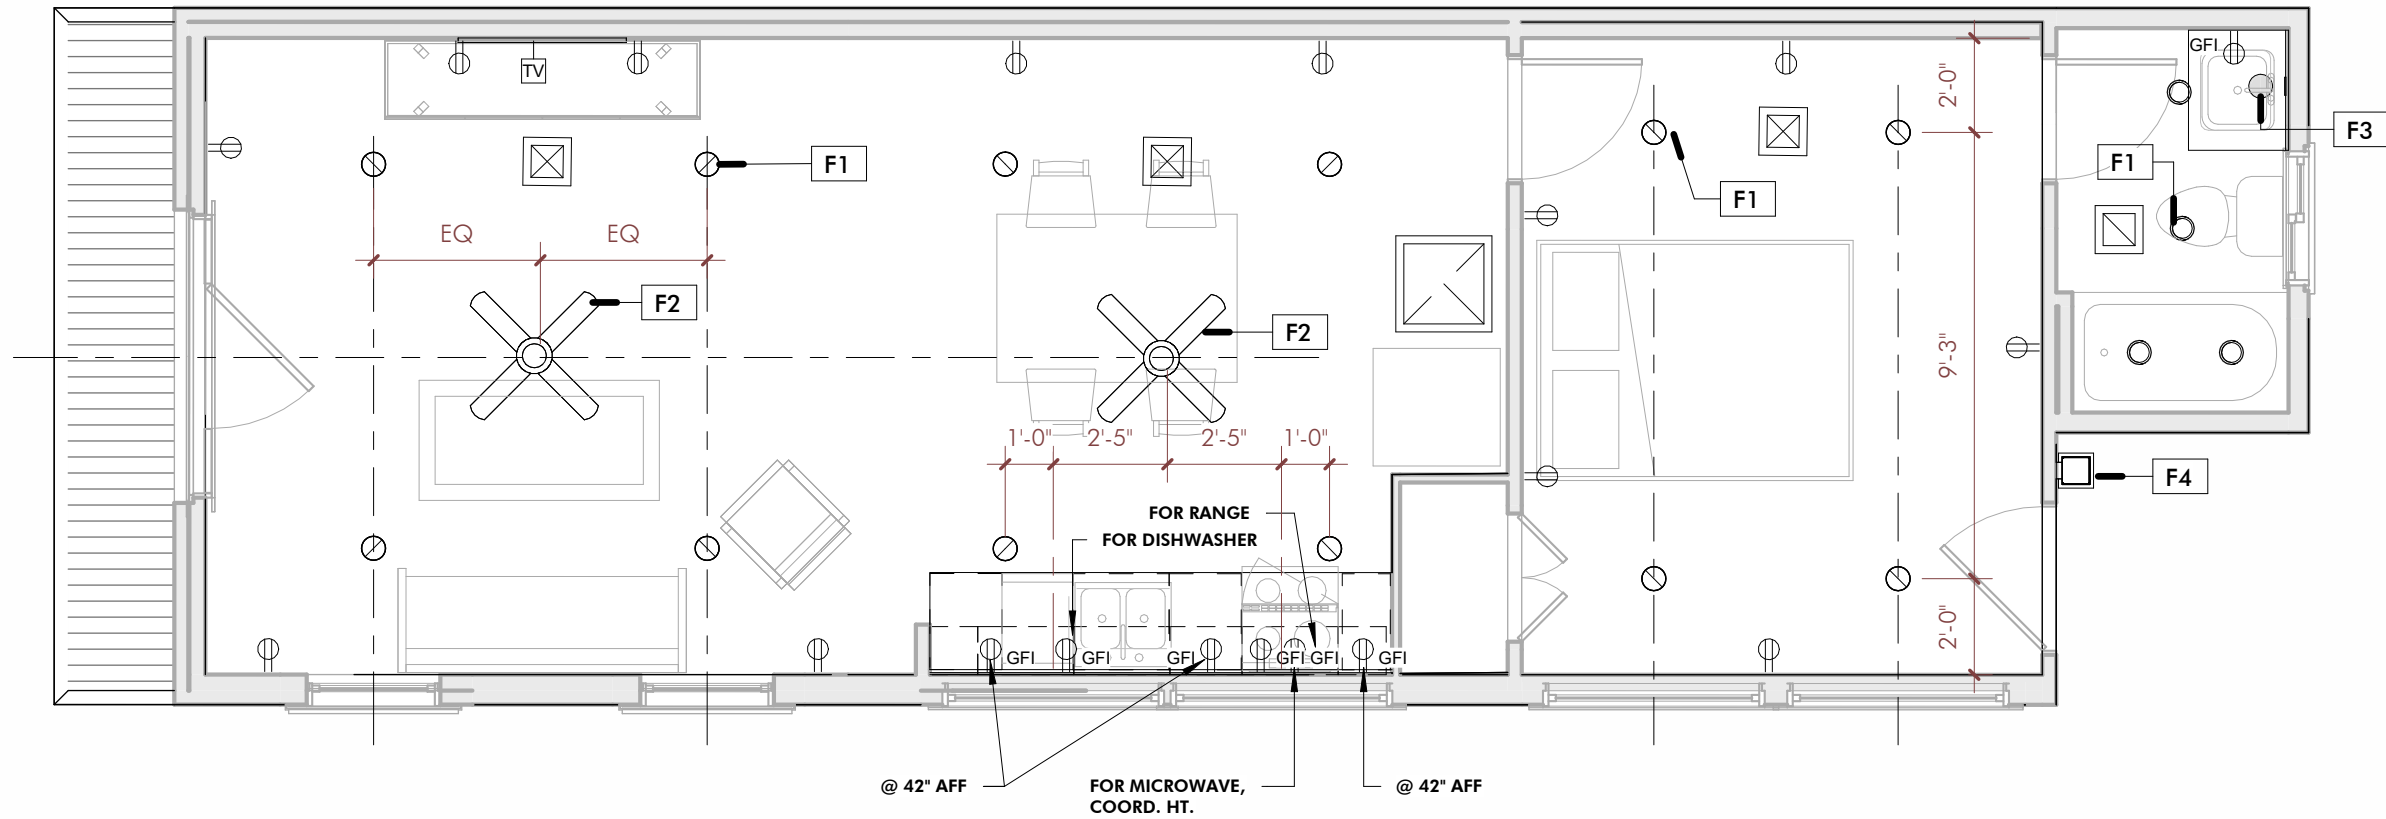

6 Floor 1 - Reflected Ceiling Plan
1/4\"/>

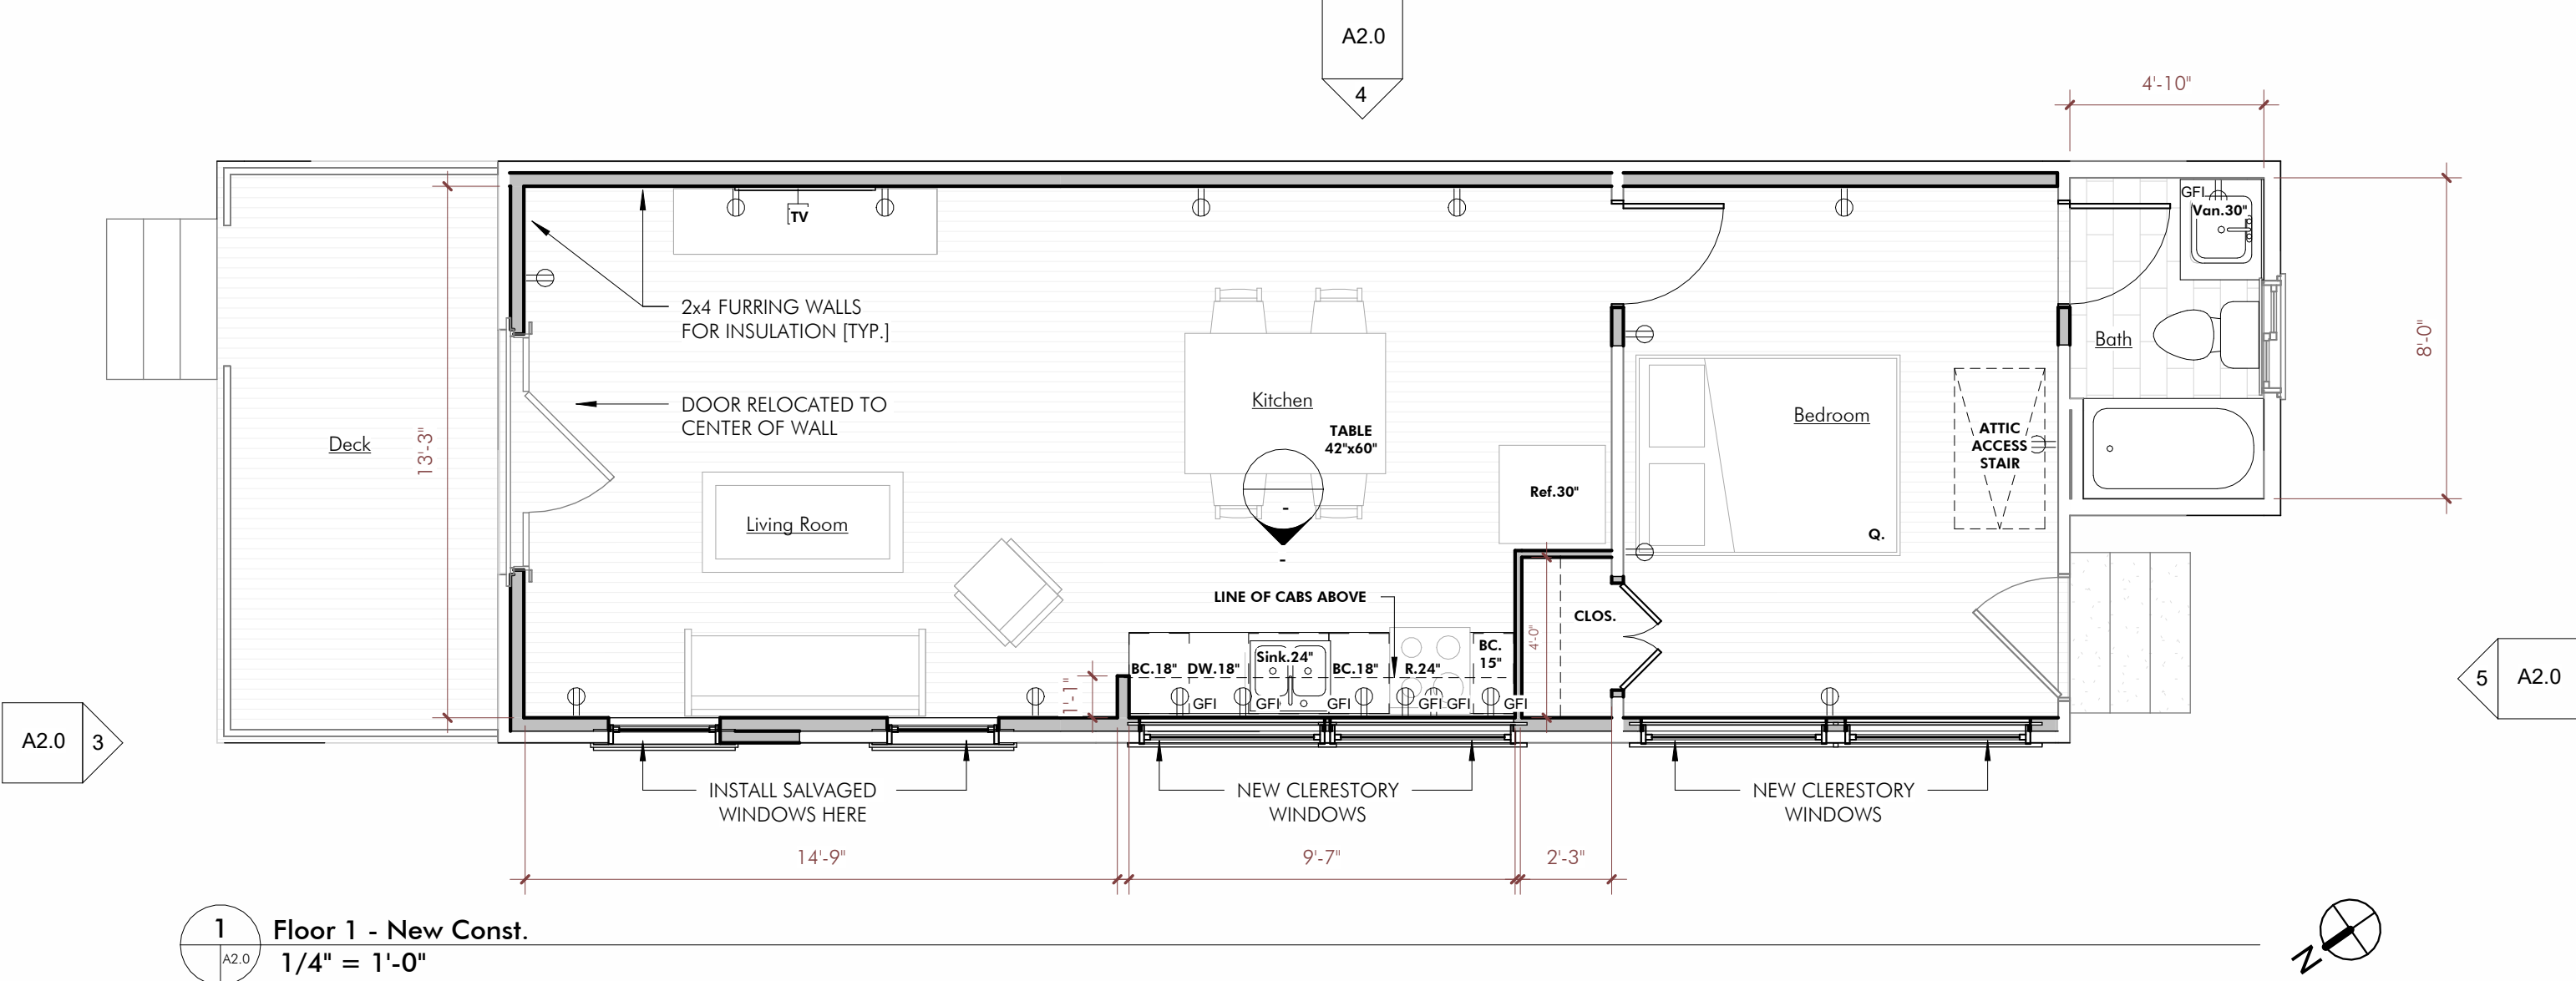

1 Floor 1 - New Const.
1/4\"/>

WALL TYPE LEGEND	
	EXISTING WALL/ITEM TO REMAIN
	EXISTING WALL/ITEM TO BE DEMOLISHED
	NEW WALL, UNRATED

CHRISTOPHER E. JOHNSON ARCHITECT LLC
WWW.CEARCHITECT.COM
CHRIS@CEARCHITECT.COM
504.231.1715

FOR PRICING ONLY
NOT FOR CONSTRUCTION

INTERIOR RENOVATION
2926 ST. PHILIP STREET
NEW ORLEANS, LOUISIANA

DATE	ISSUED FOR
02-20-2026	DRAFT

THESE PLANS HAVE BEEN PREPARED UNDER MY DIRECT SUPERVISION AND TO THE BEST OF MY KNOWLEDGE COMPLY WITH THE INTERNATIONAL BUILDING CODE. I WILL OBSERVE THE WORK.

PROJECT NO.	25.24.00
DRAWN BY	Author
CHECKED BY	Checker
DRAWING TITLE	

NEW - FLOOR PLAN AND ELEVATIONS

SHEET NO. A2.0